



# Project Info

OUTDOOR SUMMER KITCHEN  
**2220 TEQUESTA LN MIAMI, FL**



786.762.1746 | [velin-design.com](http://velin-design.com) | [Velindesign.build@gmail.com](mailto:Velindesign.build@gmail.com)

# Finishes & Appliances



Built-In 700 Series 32 in.  
4-Burner Propane Gas  
Model # BIG32RBPSS-1



Model # C121R-S-R  
Coyote 21 Inch 4.1 Cu.  
Ft. Outdoor Rated Right  
Hinge Built-In  
Refrigerator



Model #TF-NK-  
19U19x15" Undermount  
Sink



Blue Jean Patterned Zellige 4"x4"  
**Grout Recommendation :** "Mapei  
UltraColor Plus FA - Light Almond"




Cylinder in a Built-  
in Enclosure

Model #  
DHAD32-C  
Delta Heat 32-  
Inch Stainless  
Steel Double  
Access

Model # C3-  
SA2014  
Coyote 14 Inch  
Single Access  
Door - C3-  
SA2014

Model # AXE-30  
Alfresco 30-Inch  
Double Access  
Doors - AXE-30

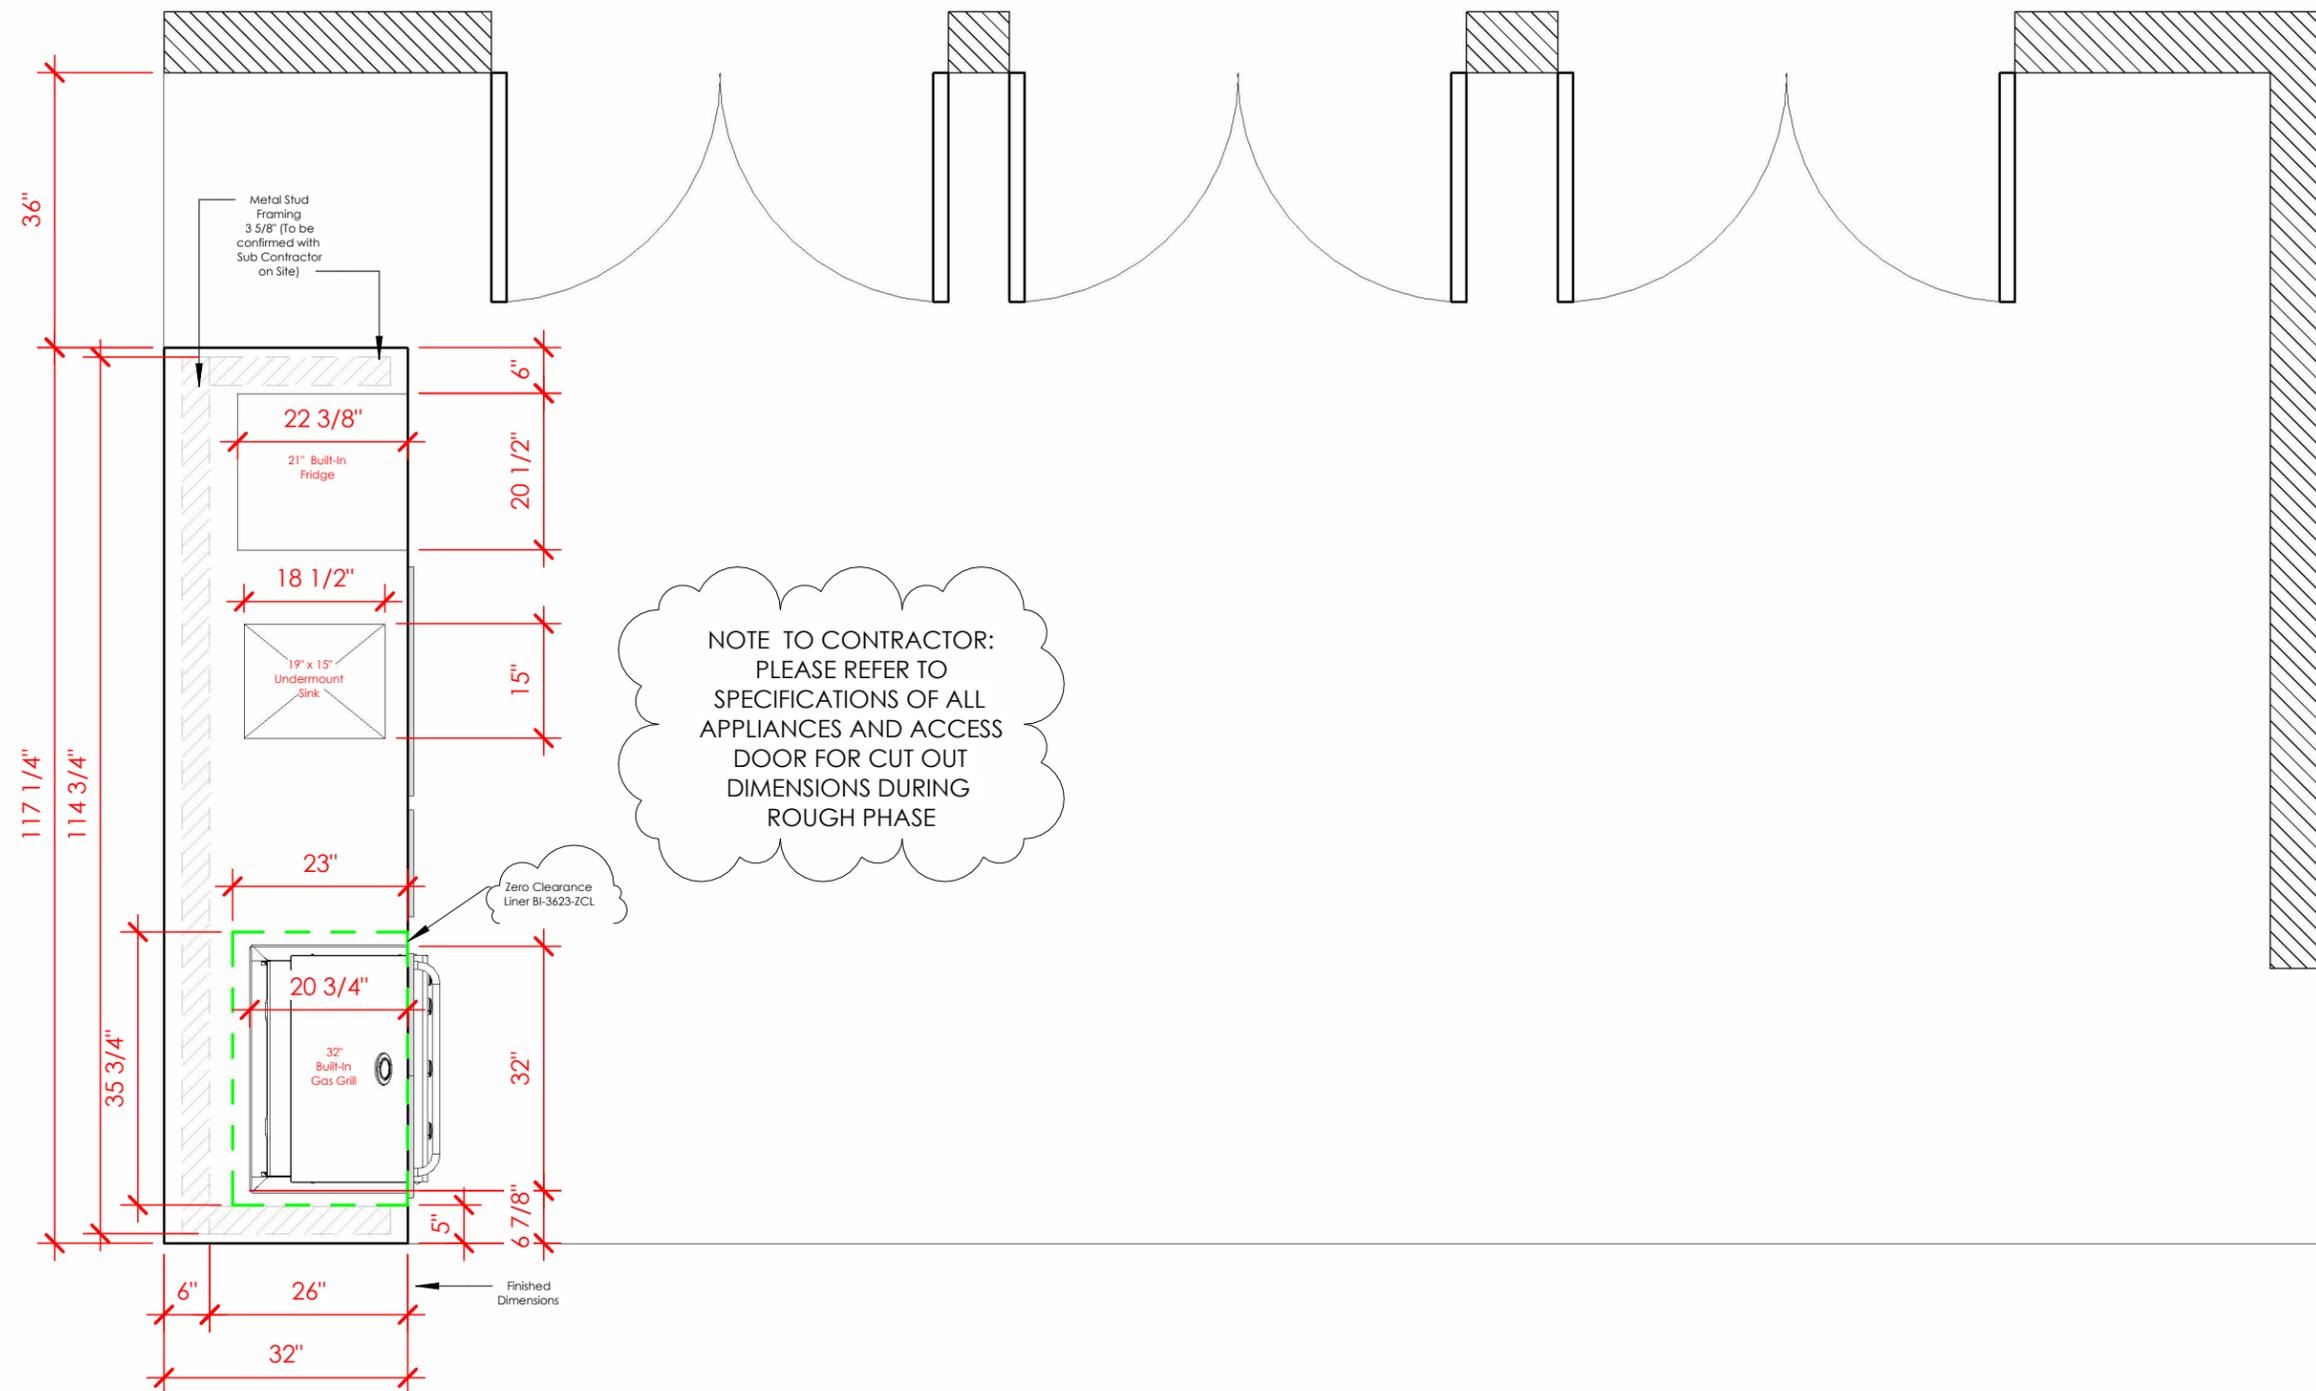

Evelyn Buduen  
Velindesign.build@gmail.com  
velin-design.com  
786.762.1746



Project

2220 TEQUESTA LN MIAMI, FL 33154  
SUMMER KITCHEN

Revision / Date

FEBRUARY 4, 2026  
V. 2


SHEET

FLOOR PLAN 01

SCALE 1/2" = 1'-0"

NOTE: Drawings are for design intent only. GC and licensed trades shall verify all dimensions, outlet locations, and Electrical/Plumbing requirements, and ensure full compliance with FBC, NEC, local codes, and manufacturer specifications.

NOTE TO CONTRACTOR:  
PLEASE REFER TO  
SPECIFICATIONS OF ALL  
APPLIANCES AND ACCESS  
DOOR FOR CUT OUT  
DIMENSIONS DURING  
ROUGH PHASE

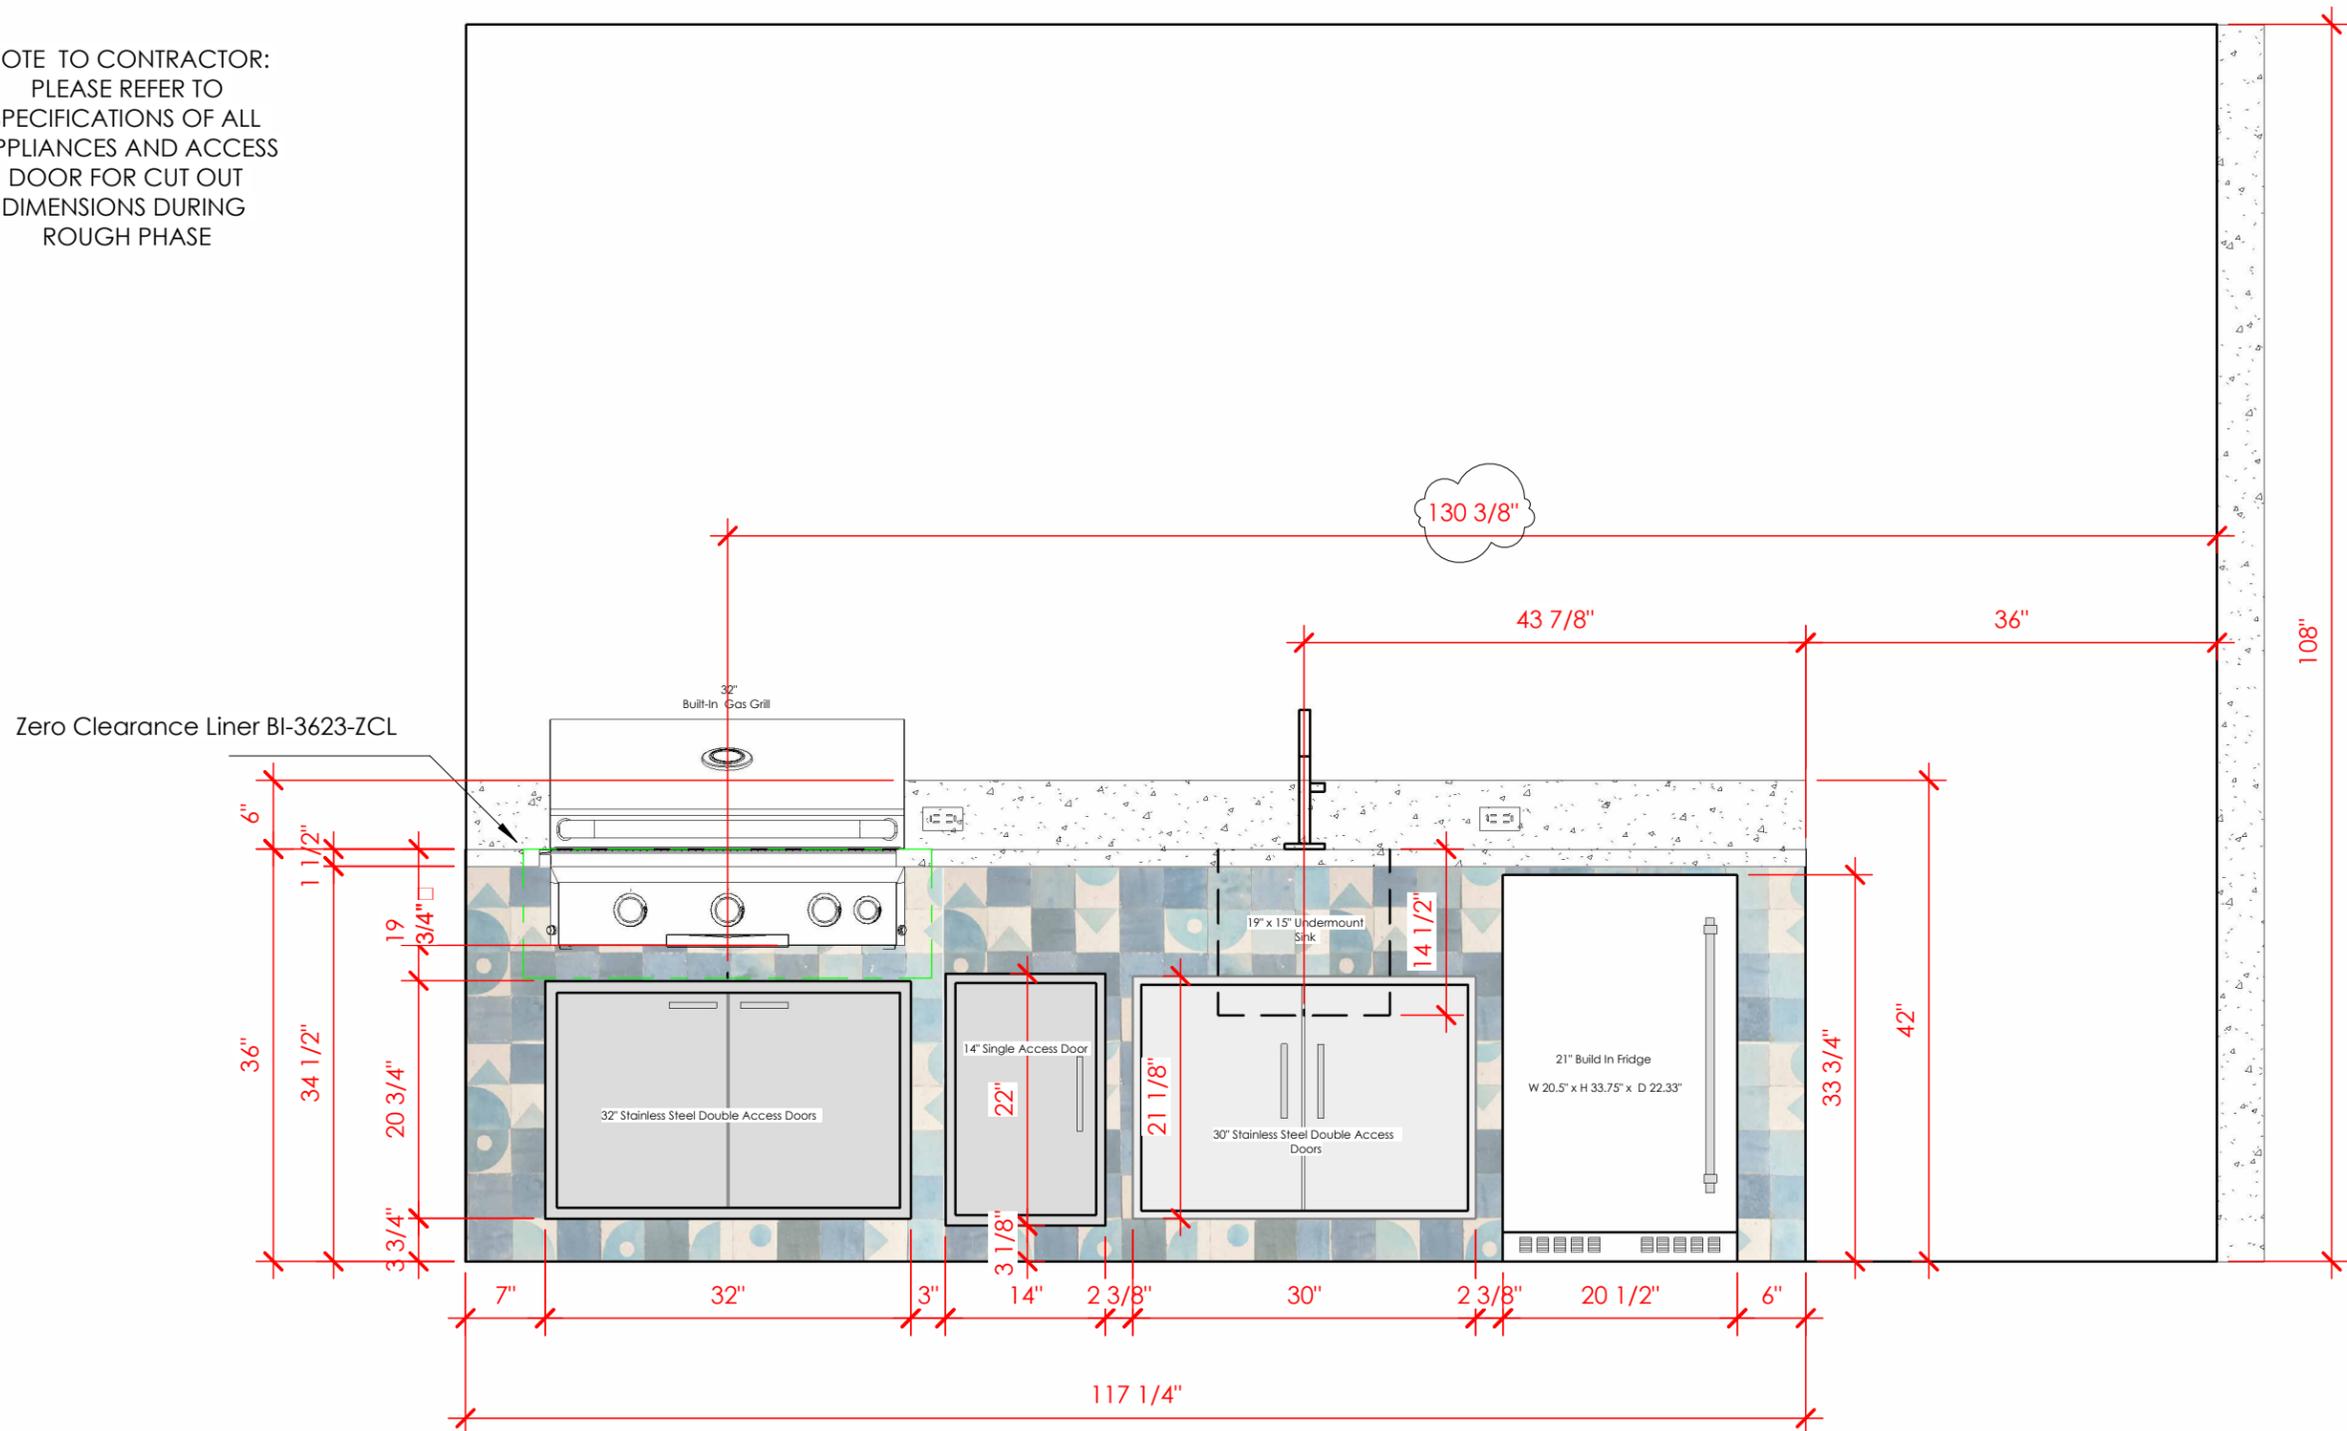

Evelyn Buduen  
Velindesign.build@gmail.com  
velin-design.com  
786.762.1746



Project  
**2220 TEQUESTA LN MIAMI, FL 33154**  
**SUMMER KITCHEN**


Revision / Date  
**FEBRUARY 4, 2026**  
**V. 2**

**SHEET**


**ELEVATION 02**  
SCALE 3/4" = 1'-0"

NOTE: Drawings are for design intent only. GC and licensed trades shall verify all dimensions, outlet locations, and Electrical/Plumbing requirements, and ensure full compliance with FBC, NEC, local codes, and manufacturer specifications.


LP GAS CYLINDER ENCLOSURE  
 Provide (2) exterior ventilation  
 openings (high & low).  
 Lower vent min. 2" above  
 finished floor.  
 Vent openings sized and  
 located per manufacturer  
 requirements

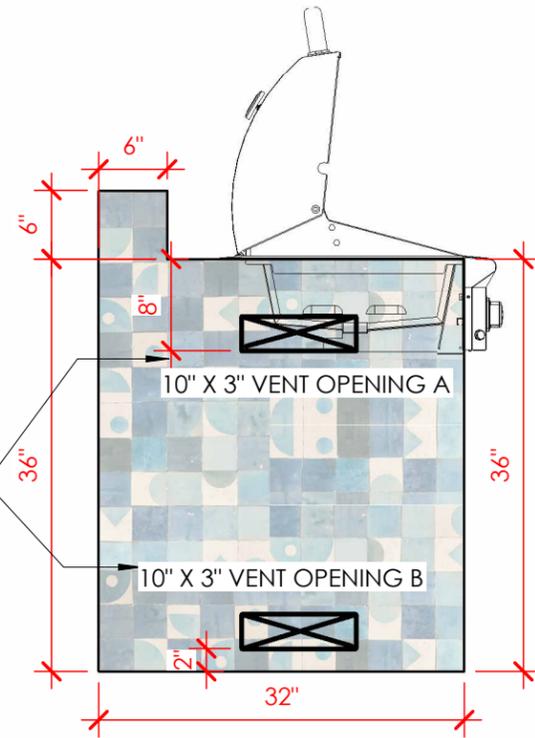

LEFT SIDE VIEW

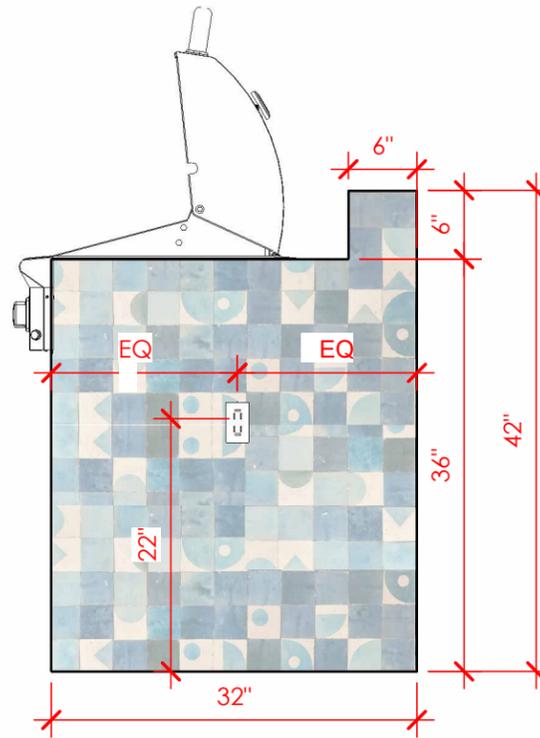

RIGHT SIDE VIEW

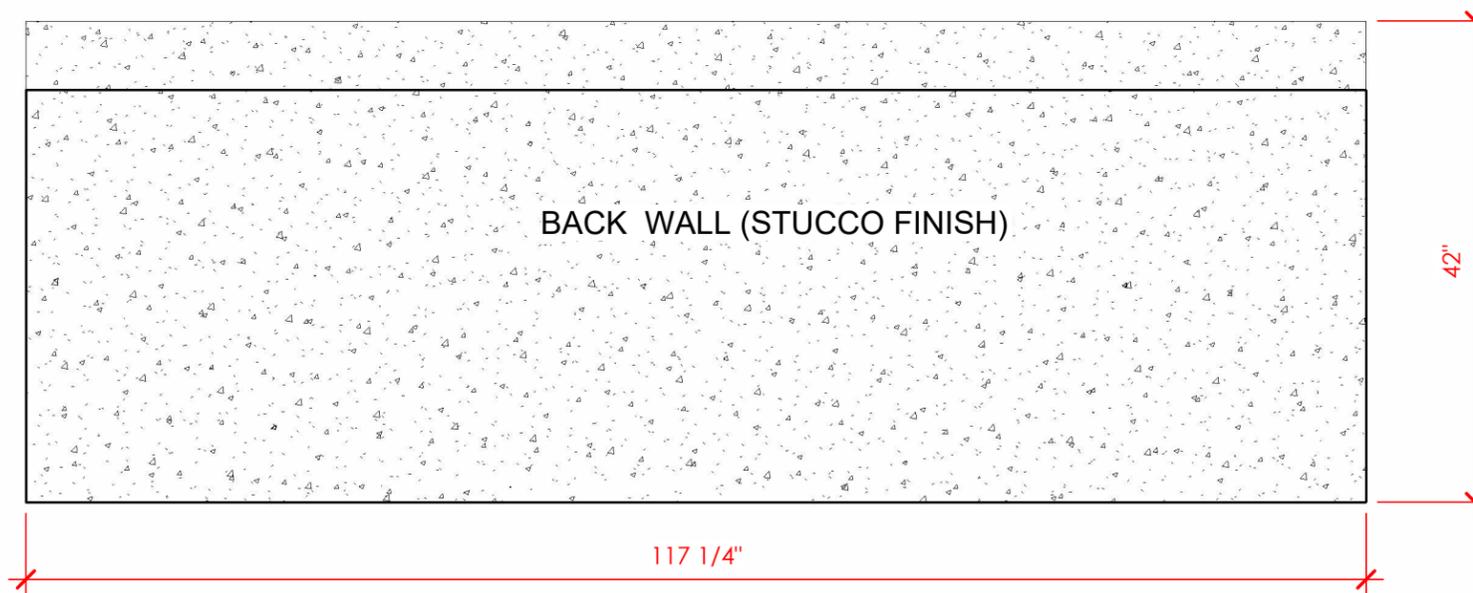

Evelyn Buduen  
 Velindesign.build@gmail.com  
 velin-design.com  
 786.762.1746



Project

2220 TEQUESTA LN MIAMI, FL 33154  
 SUMMER KITCHEN

Revision / Date



FEBRUARY 4, 2026  
 V. 2

SHEET

ELEVATION 02

SCALE 3/4" = 1'-0"

NOTE: Drawings are for design intent only. GC and licensed trades shall verify all dimensions, outlet locations, and Electrical/Plumbing requirements, and ensure full compliance with FBC, NEC, local codes, and manufacturer specifications.

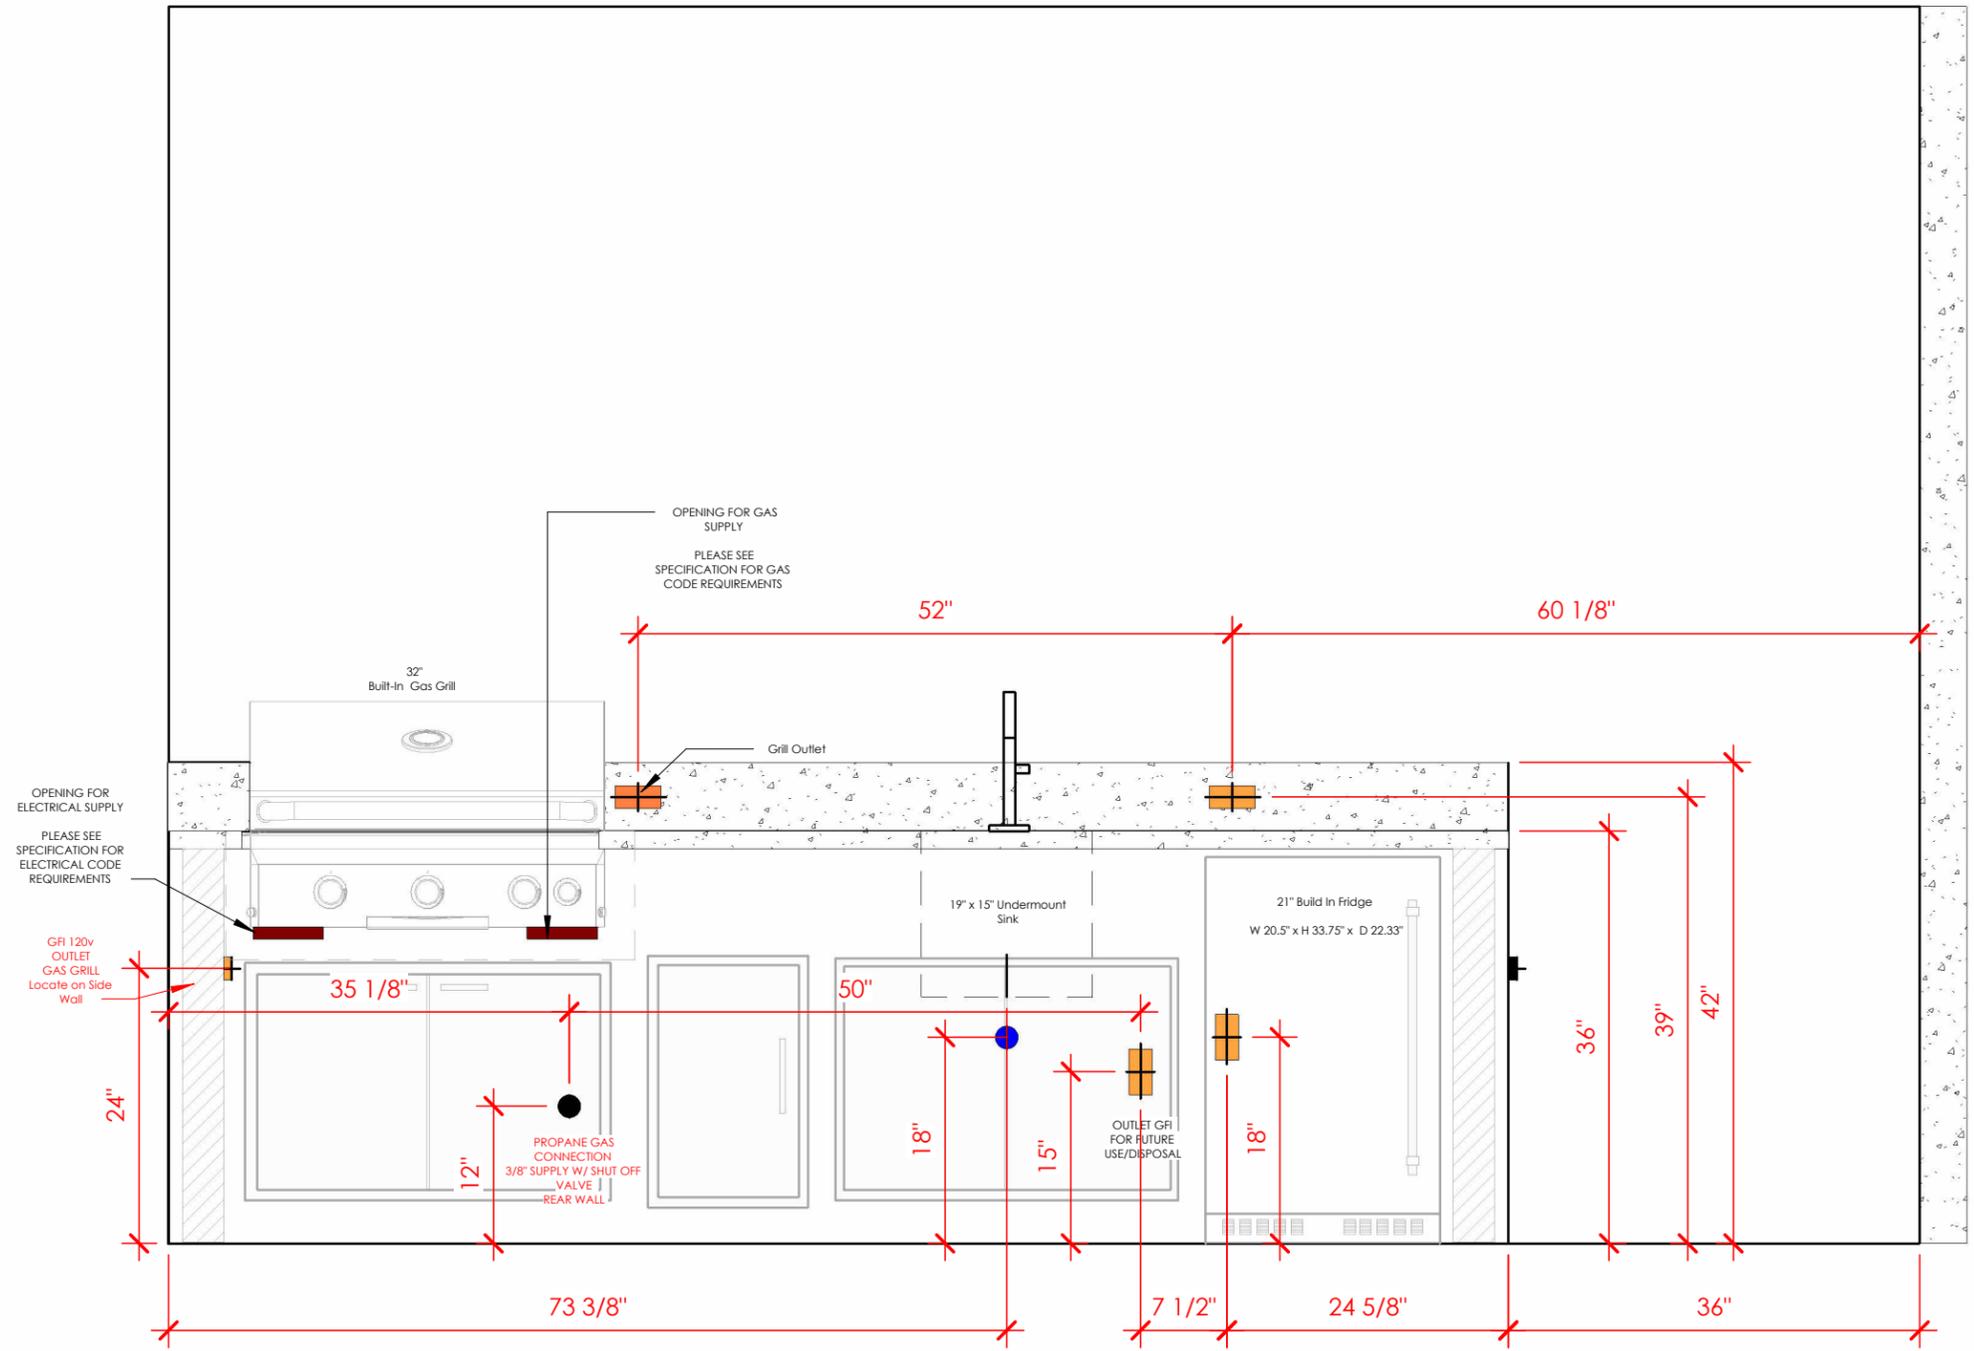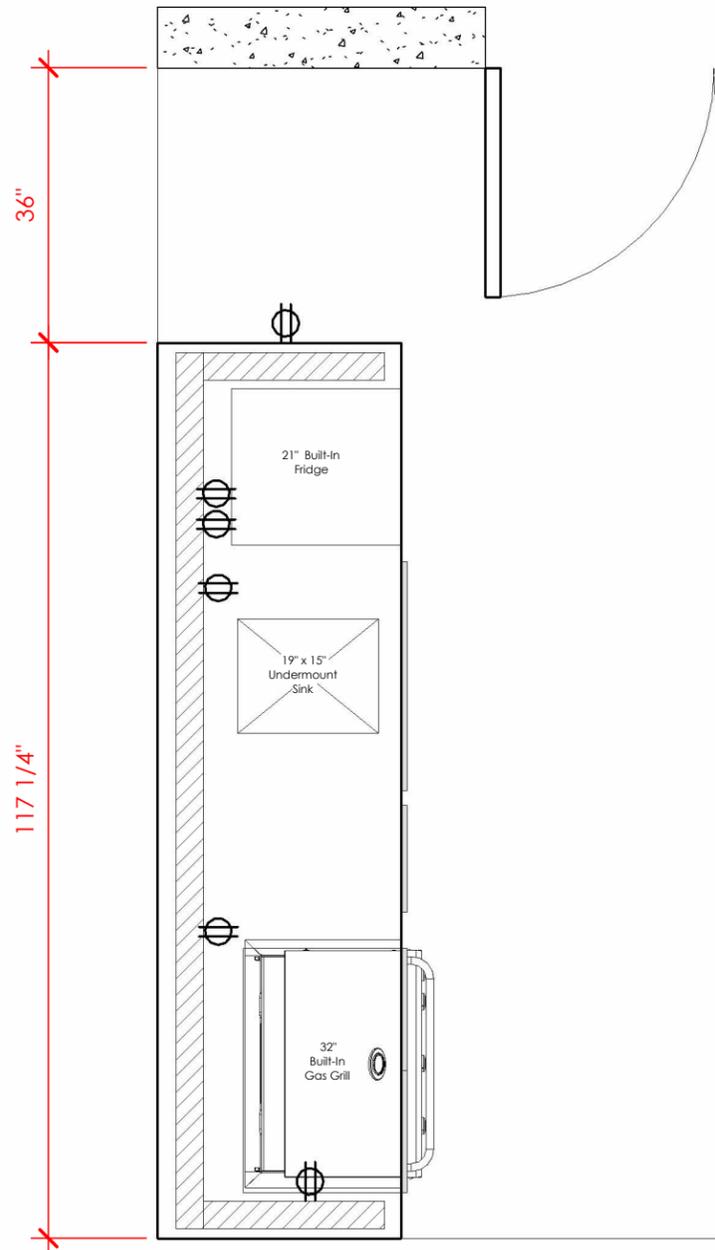

Evelyn Buduen  
 Velindesign.build@gmail.com  
 velin-design.com  
 786.762.1746



Project

2220 TEQUESTA LN MIAMI, FL 33154  
 SUMMER KITCHEN

Revision / Date

JANUARY 2, 2026

SHEET

ELECTRICAL PLAN 03

NOTE: Drawings are for design intent only. GC and licensed trades shall verify all dimensions, outlet locations, and Electrical/Plumbing requirements, and ensure full compliance with FBC, NEC, local codes, and manufacturer specifications.